



Ordnance Survey, (c) Crown Copyright 2021. All rights reserved. Licence number 100022432

DRAWING NOTES

COPYRIGHT ©
This drawing and the details herein are the copyright of MBH Design Studio Ltd. and must not be reproduced, altered or passed to any third party without prior written consent.

This drawing has been produced for the project listed below, is submitted in support of this application application to the Local Planning Authority and is not intended for use by any other person or for any other purpose.

Every effort has been made to ensure the accuracy of these drawings, however MBH Design Studio Ltd. accept no responsibility for any discrepancies arising from the reuse of survey information and preliminary drawings commissioned by the Applicant from others.

KEY PLAN:

 SITE BOUNDARY LINE

REV	DATE	DESCRIPTION	DRAWN/CHECKED
-----	------	-------------	---------------

REVISION NOTES

PLANNING



MBH Design Studio Ltd.
Rosemount House, Rosemount Avenue, West Byfleet, Surrey, KT14 6LB
www.mbhstl.com t: 01932 352 727 f: 01932 351 545


CLIENT



PROJECT
FS286 WALSGRAVE SERVICE STATION
HINCLEY ROAD
WALSGRAVE ON SOWE
CV2 2QN

DRAWING TITLE
LOCATION PLAN

DRAWN BY	DATE	SCALE	PAPER SIZE
ACM	10.03.2022	1:1000	A4
CHECKED BY	DRAWING NUMBER	REV.	
RRB	13664-LP-286	.	

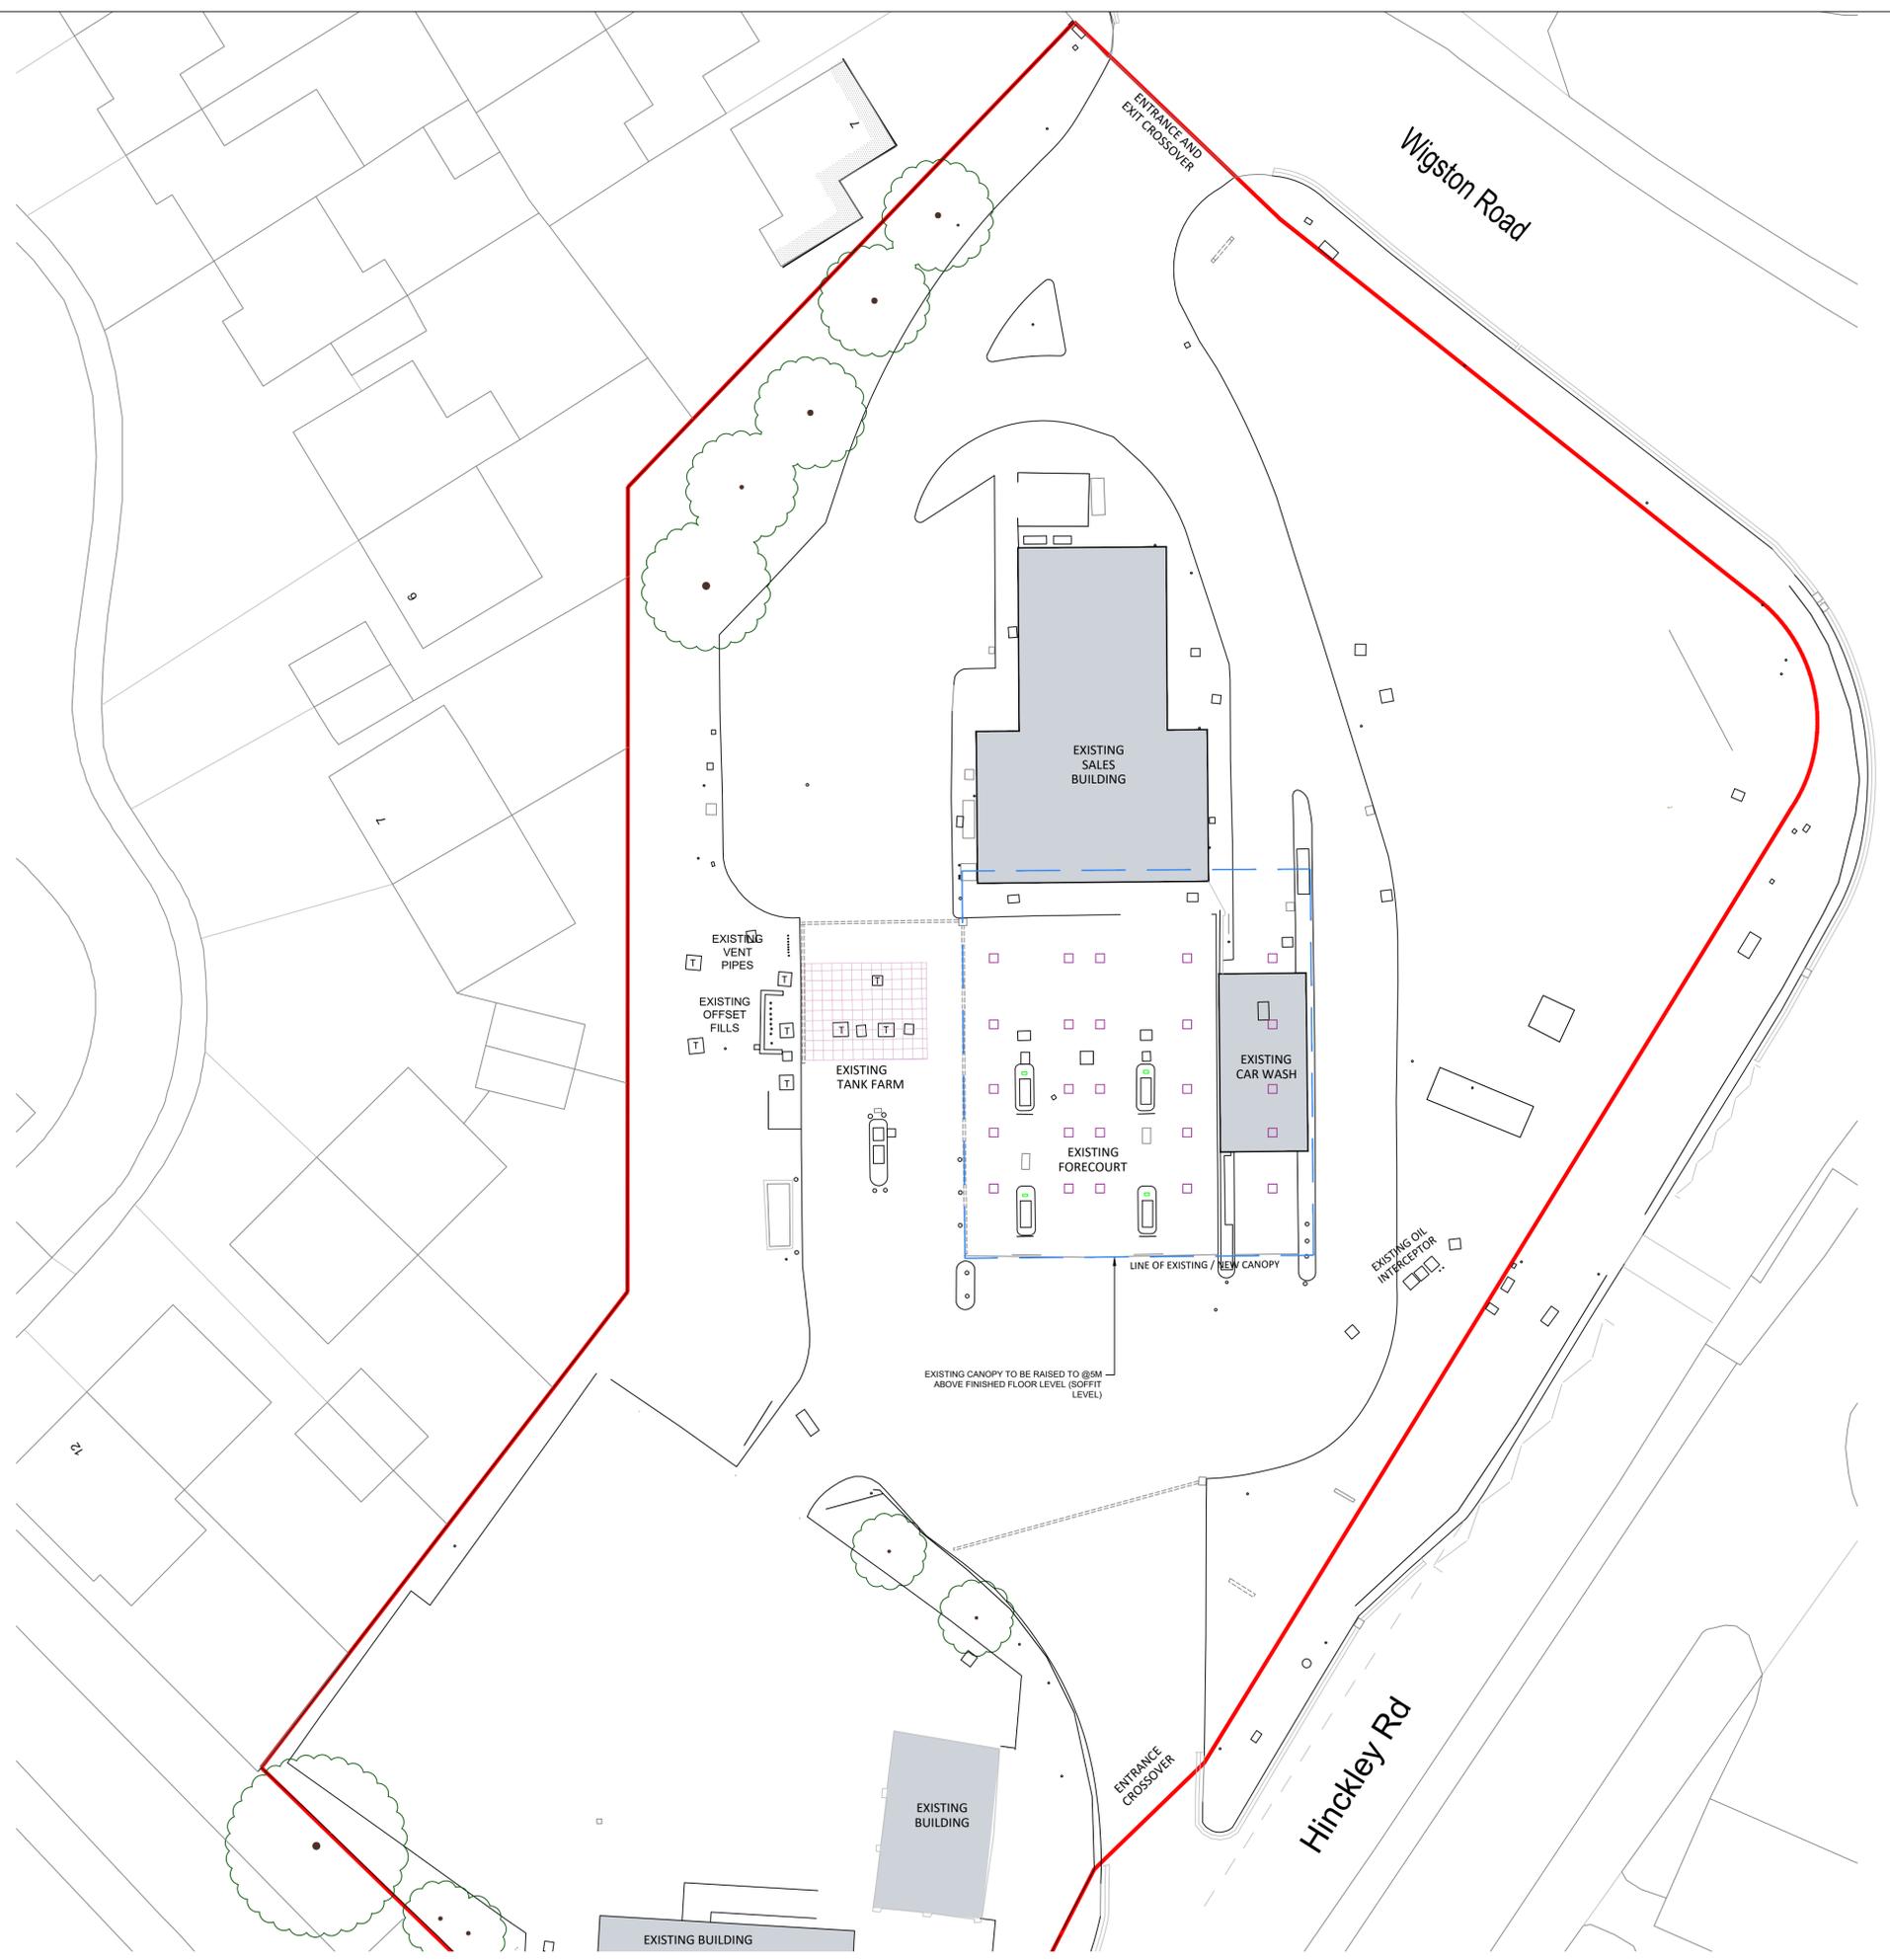


DRAWING NOTES

COPYRIGHT ©
This drawing and the details herein are the copyright of MBH Design Studio Ltd. and must not be reproduced, altered or passed to any third party without prior written consent.

This drawing has been produced for the project listed below, is submitted in support of this application application to the Local Planning Authority and is not intended for use by any other person or for any other purpose.

Every effort has been made to ensure the accuracy of these drawings, however MBH Design Studio Ltd. accept no responsibility for any discrepancies arising from the reuse of survey information and preliminary drawings commissioned by the Applicant from others.

 □ DENOTES EXISTING PHILLIPS HPL-T 250W CANOPY LIGHT



REV	DATE	DESCRIPTION	DRAWN/CHECKED
REVISION NOTES			

PLANNING



MBH Design Studio Ltd.
Rosemount House, Rosemount Avenue, West Byfleet, Surrey, KT14 6LB
www.mbhstd.com t: 01932 352 727 f: 01932 351 545



CLIENT


PROJECT
FS286 WALSGRAVE SERVICE STATION
HINCKLEY ROAD
WALSGRAVE ON SOWE
CV2 2QN

DRAWING TITLE
PROPOSED SITE LAYOUT


DRAWN BY ACM	DATE 10.03.2022	SCALE 1:200	PAPER SIZE A1
CHECKED BY RRB	DRAWING NUMBER 13664-P02-286	REV. .	




DRAWING NOTES
 COPYRIGHT ©
 This drawing and the details herein are the copyright of MBH Design Studio Ltd. and must not be reproduced, altered or passed to any third party without prior written consent.
 This drawing has been produced for the project listed below, is submitted in support of this application to the Local Planning Authority and is not intended for use by any other person or for any other purpose.
 Every effort has been made to ensure the accuracy of these drawings, however MBH Design Studio Ltd. accept no responsibility for any discrepancies arising from the reuse of survey information and preliminary drawings commissioned by the Applicant from others.

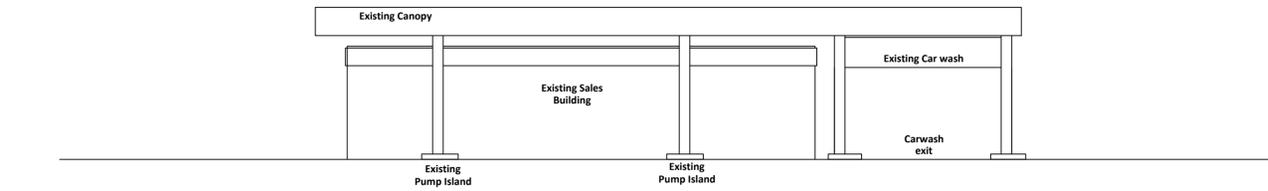


ELEVATION - A
 Scale 1:50

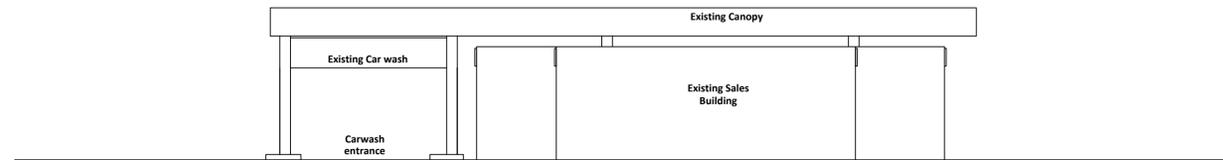


ELEVATION - B
 Scale 1:50

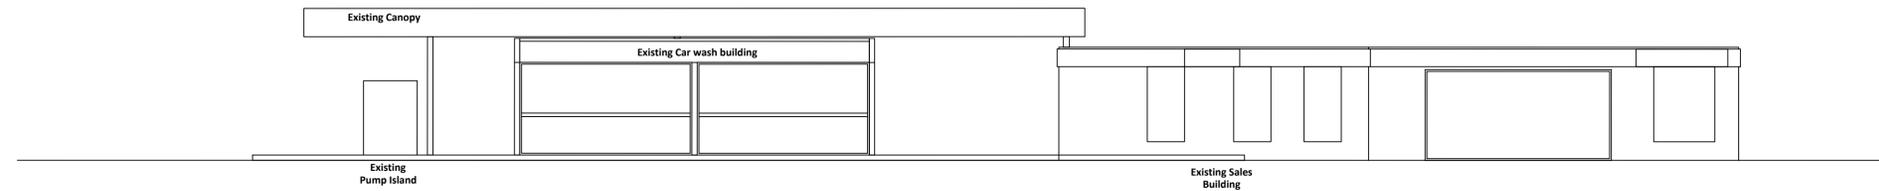

ELEVATION - C
 Scale 1:50

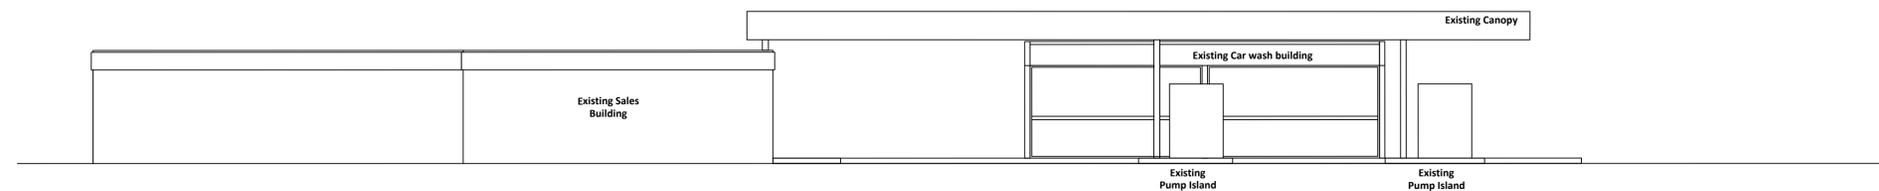

ELEVATION - D
 Scale 1:50

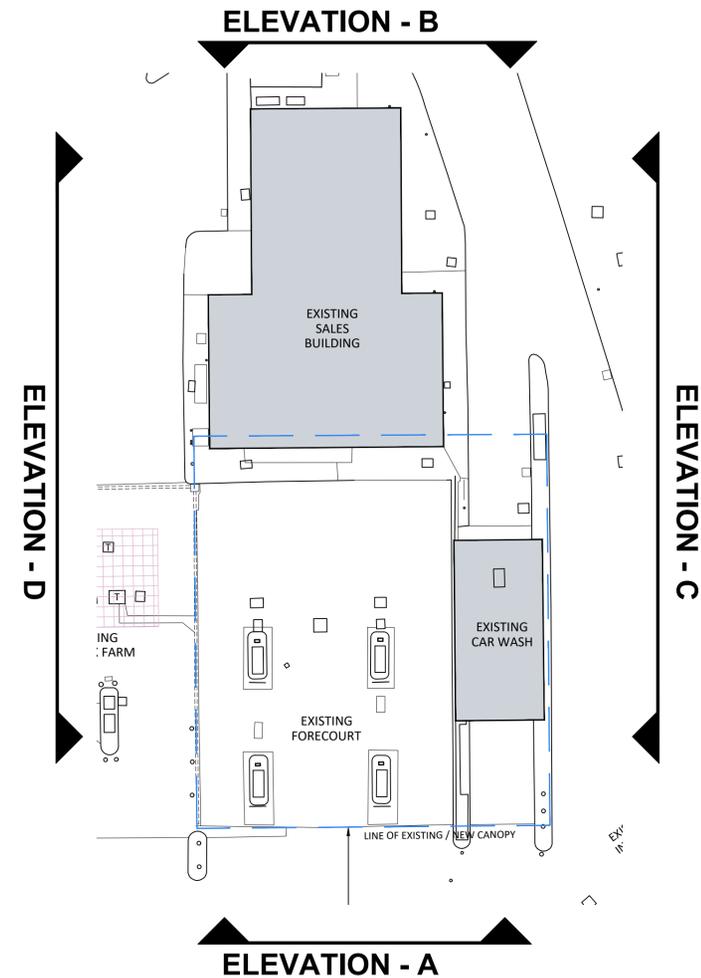

SALES BUILDING AND FORECOURT PLAN
 Scale 1:200



REV	DATE	DESCRIPTION	DRAWN/CHECKED
REVISION NOTES			

PLANNING



MBH Design Studio Ltd.
 Rosemount House, Rosemount Avenue, West Byfleet, Surrey, KT14 6LB
 www.mbhstd.com t: 01932 352 727 f: 01932 351 545




CLIENT
PROJECT
 FS286 WALSGRAVE SERVICE STATION
 HINCKLEY ROAD
 WALSGRAVE ON SOWE
 CV2 2QN

DRAWING TITLE
 EXISTING ELEVATIONS


DRAWN BY ACM	DATE 10.03.2022	SCALE 1:50	PAPER SIZE A1
CHECKED BY RRB	DRAWING NUMBER 13664-P05-286	REV. .	




DRAWING NOTES
 COPYRIGHT ©
 This drawing and the details herein are the copyright of MBH Design Studio Ltd. and must not be reproduced, altered or passed to any third party without prior written consent.
 This drawing has been produced for the project listed below, is submitted in support of this application to the Local Planning Authority and is not intended for use by any other person or for any other purpose.
 Every effort has been made to ensure the accuracy of these drawings, however MBH Design Studio Ltd. accept no responsibility for any discrepancies arising from the reuse of survey information and preliminary drawings commissioned by the Applicant from others.

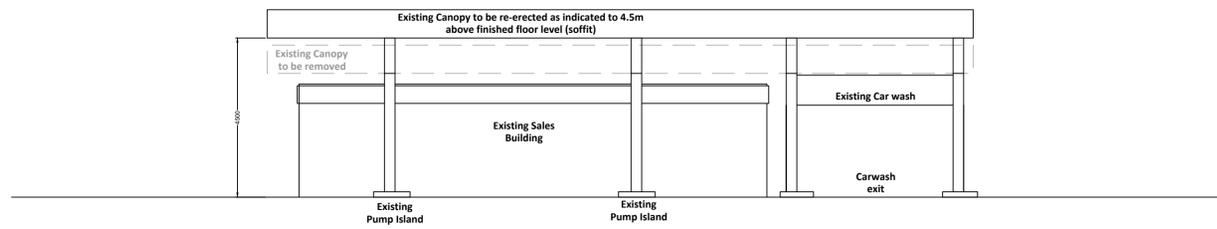


ELEVATION - A
 Scale 1:50

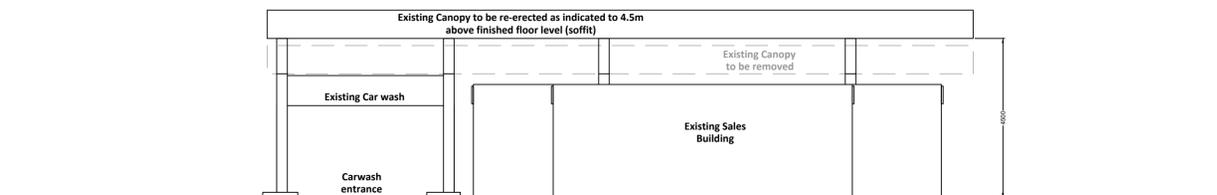


ELEVATION - B
 Scale 1:50

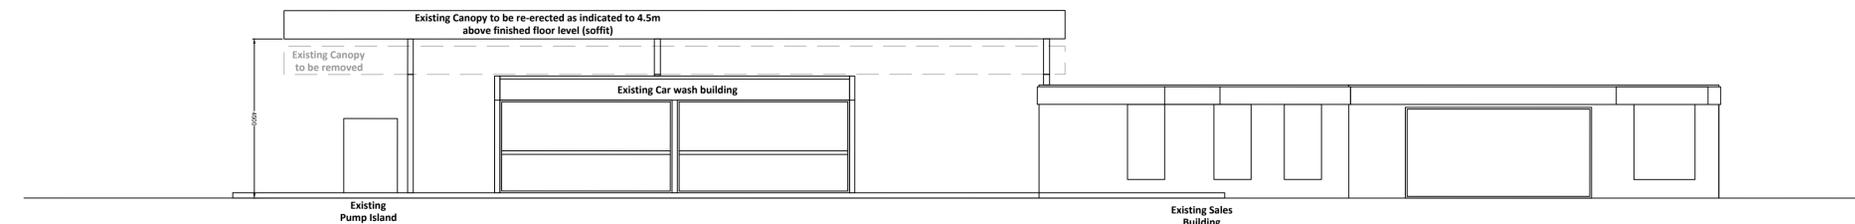


ELEVATION - C
 Scale 1:50

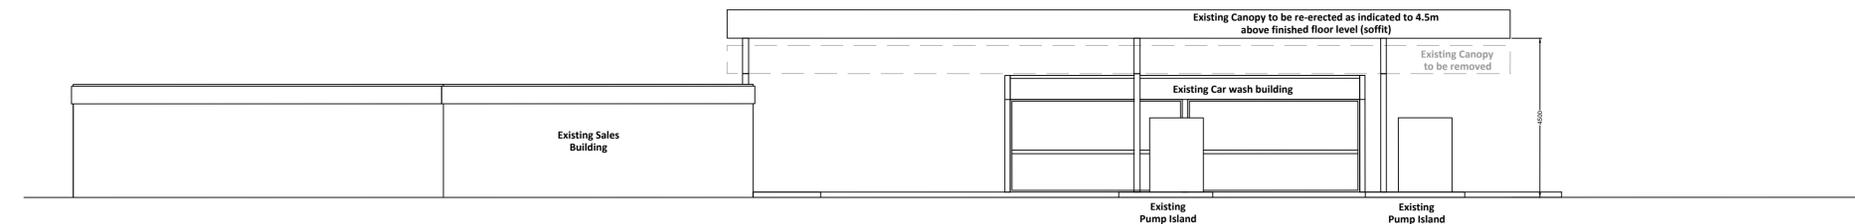

ELEVATION - D
 Scale 1:50

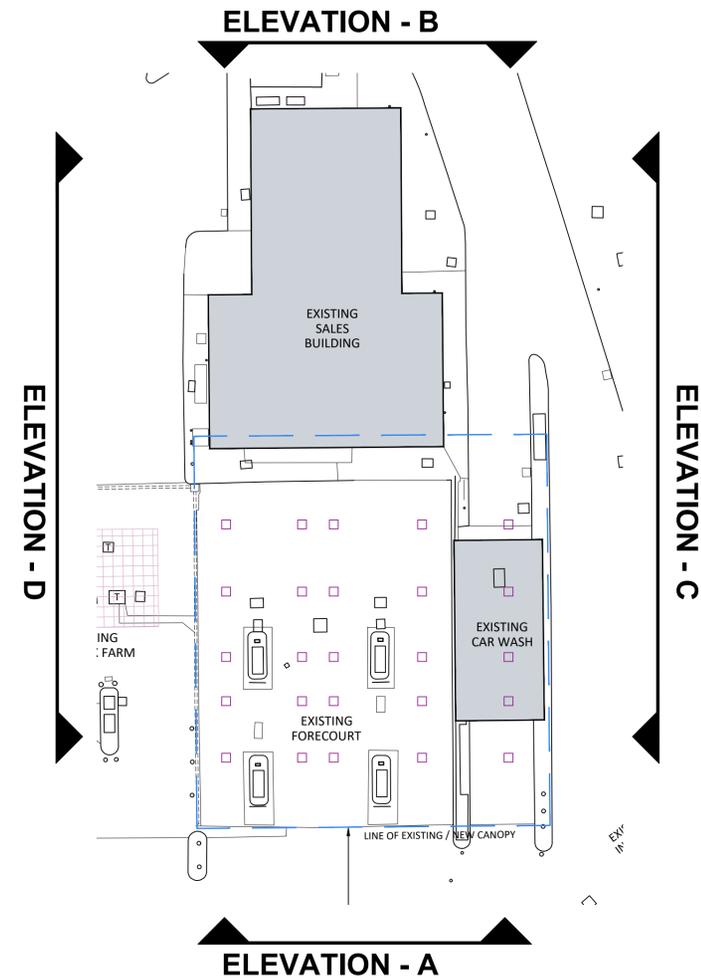

 SALES BUILDING AND FORECOURT PLAN
 Scale 1:200



REV	DATE	DESCRIPTION	DRAWN/CHECKED
B	27.07.2023	UPDATED CANOPY LEVEL	WG/NS
A	12.04.2023	Update Canopy level	KM/RRB

REVISION NOTES

PLANNING



MBH Design Studio Ltd.
 Rosemount House, Rosemount Avenue, West Byfleet, Surrey, KT14 6LB
 www.mbhstd.com t: 01932 352 727 f: 01932 351 545


CLIENT



PROJECT
 FS286 WALSGRAVE SERVICE STATION
 HINCKLEY ROAD
 WALSGRAVE ON SOWE
 CV2 2QN

DRAWING TITLE
 PROPOSED ELEVATIONS

DRAWN BY	DATE	SCALE	PAPER SIZE
ACM	10.03.2022	1:50	A1
CHECKED BY	DRAWING NUMBER	REV.	
RRB	13664-P06-286	B	

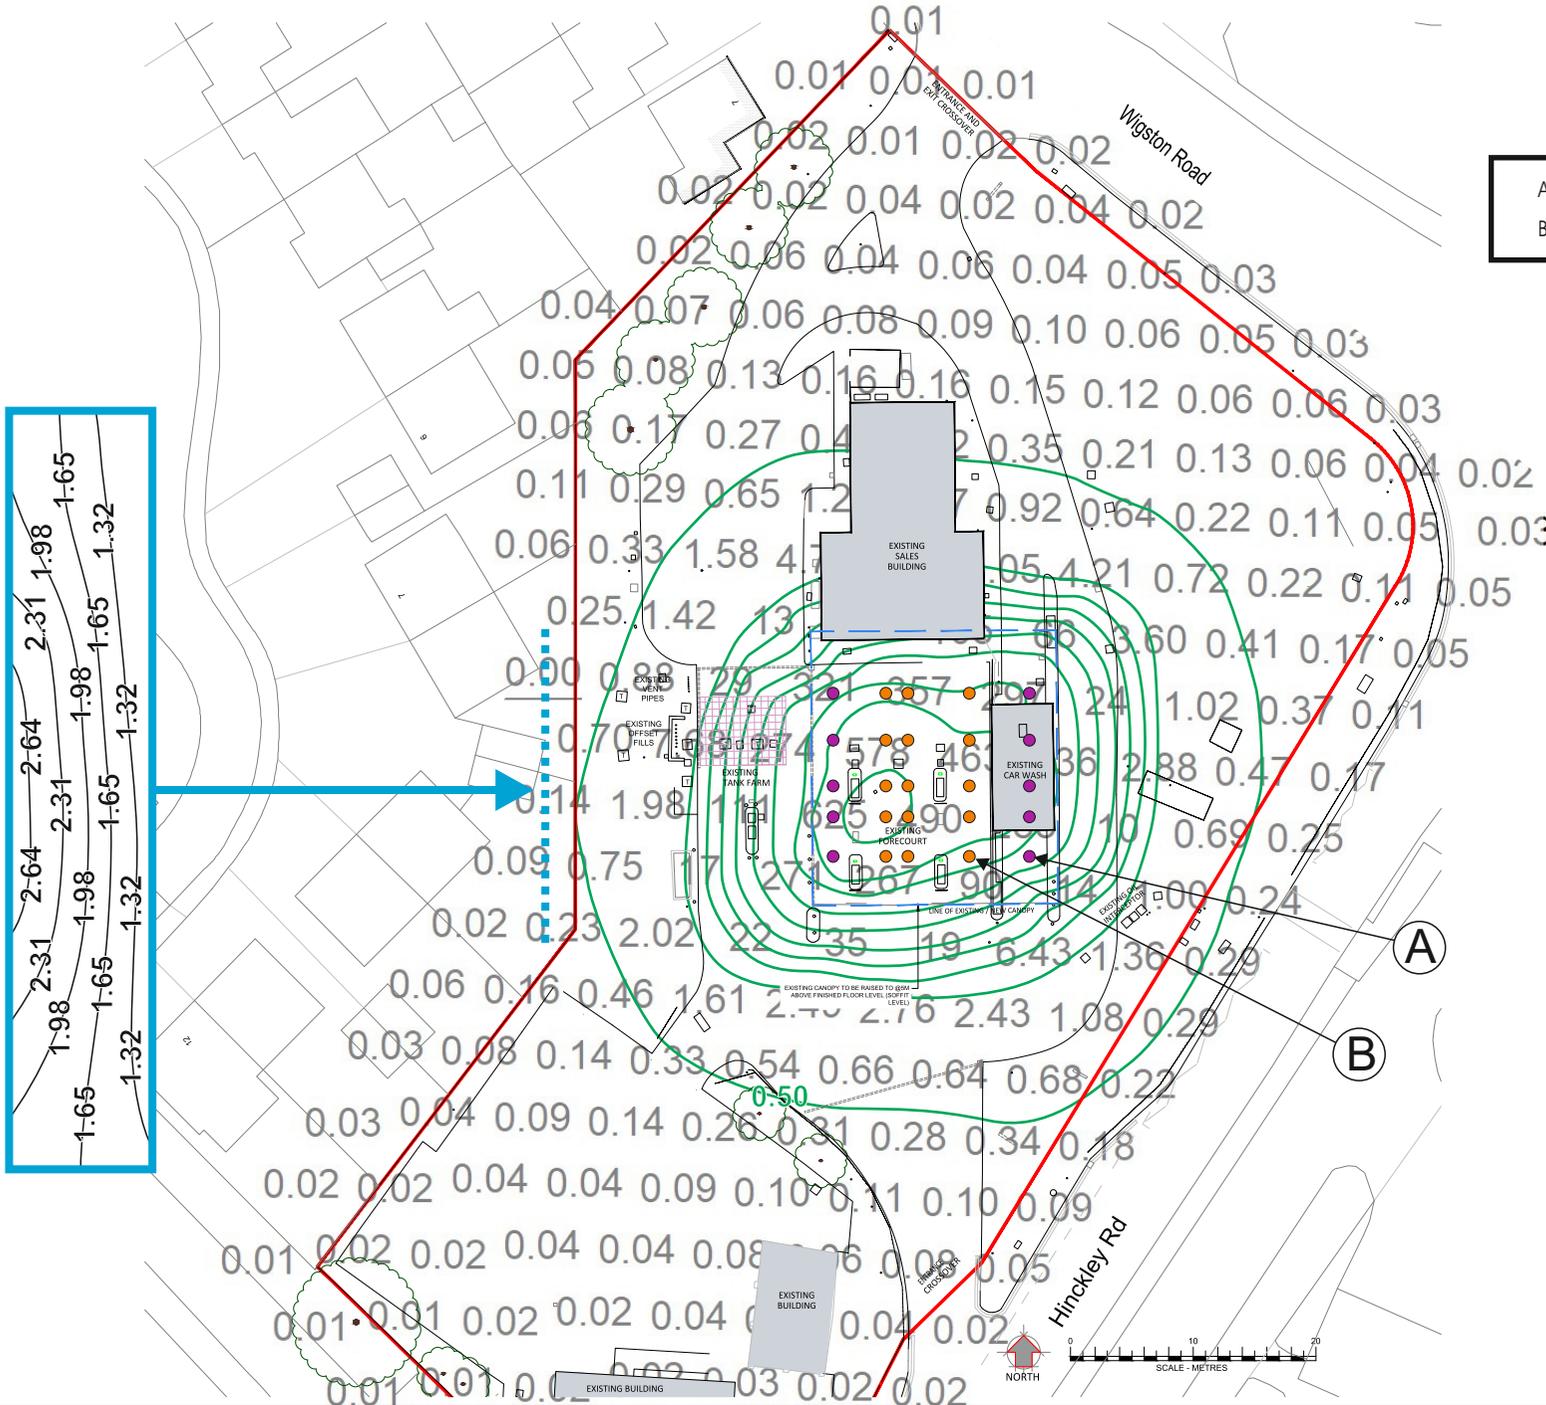

- A. ● 10 x 16762 Luci02-A-MB02-50LED
- B. ● 15 x 16759 Luci02-S-MB01-40LED

The lighting information provided on this drawing is for planning purposes only. The specified product manufacturer must be contacted for a comprehensive design and limited warranty information prior to product procurement. Emergency and Escape Lighting (not shown) is to be installed and compliant with BS5266-1 and The Regulatory Reform (Fire Safety) Order 2005 respectively.

TITLE: PROPOSED LIGHTING PLAN - WALSGRAVE SERVICE STATION
 FILE REF: DM150
 CLIENT: MBH/MFG

THE GRAHAM WHITE LIGHTING CONSULTANCY
 20 Ribston Road, Farnham, Surrey. GU9 7GR
 Mobile: 07778 523667 | e-mail: enquiries@gwlc.co.uk
 www.gwlc.co.uk

